
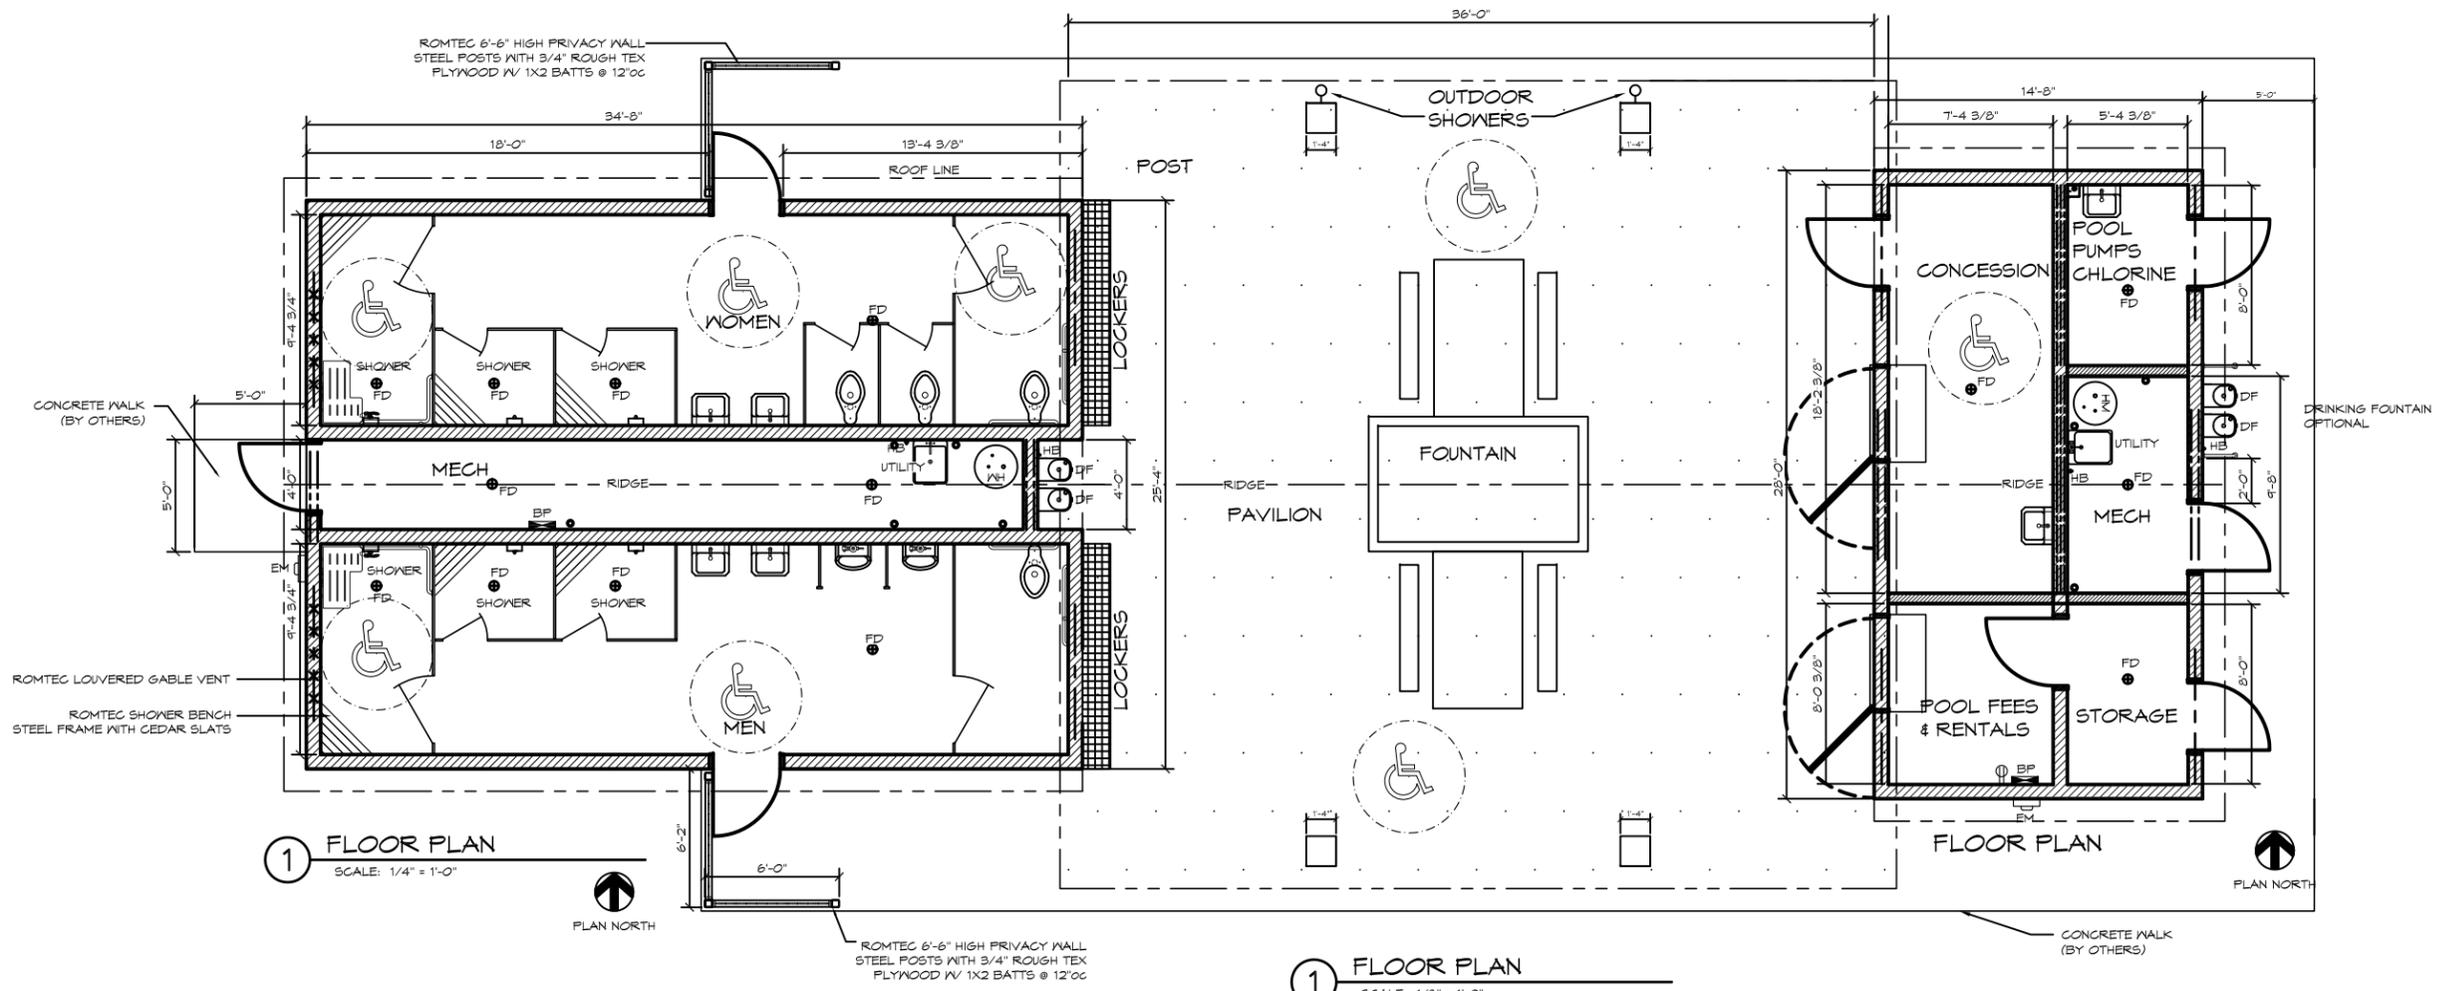


Model - 2470

LEGEND		
SYMBOL	DESCRIPTION	AREA/ QUANTITY
—	GABLE VENT	2
—	LOUVERED GABLE VENT	2
—	RIDGE VENT	2
—	EXTERIOR WALL LIGHTS	4
—	INTERIOR WALL LIGHTS	6
—	INTERIOR CEILING LIGHTS	2
⊙	FLOOR DRAIN	10
⊕	ELECTRICAL OUTLET	1

WALL TYPE SCHEDULE

	8" CMU BLOCK WALL REINFORCED & GROUT FILLED
	6" CMU BLOCK WALL REINFORCED & GROUT FILLED

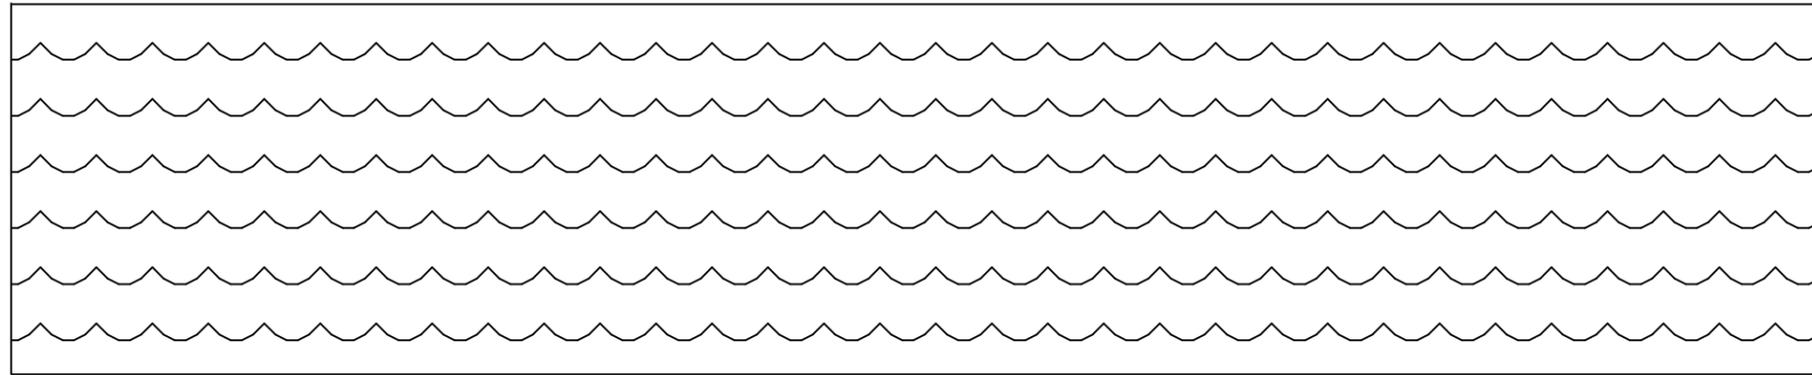

1 FLOOR PLAN
SCALE: 1/4" = 1'-0"

1 FLOOR PLAN
SCALE: 1/8" = 1'-0"

ROMTEC
18240 NORTH BANK ROAD • ROSEBURG, OR 97470
(541) 496-3541 FAX (541) 496-4803

PRELIMINARY

PROJECT: COMMUNITY POOL 001
COMMUNITY BUILDING - POOL 1
PROJECT LOCATION

PROJECT#: _____
MODEL#: POOL 1
DATE: 00/00/2014
REVISIONS

REV.	DATE	BY

DRAWN BY: TH

